


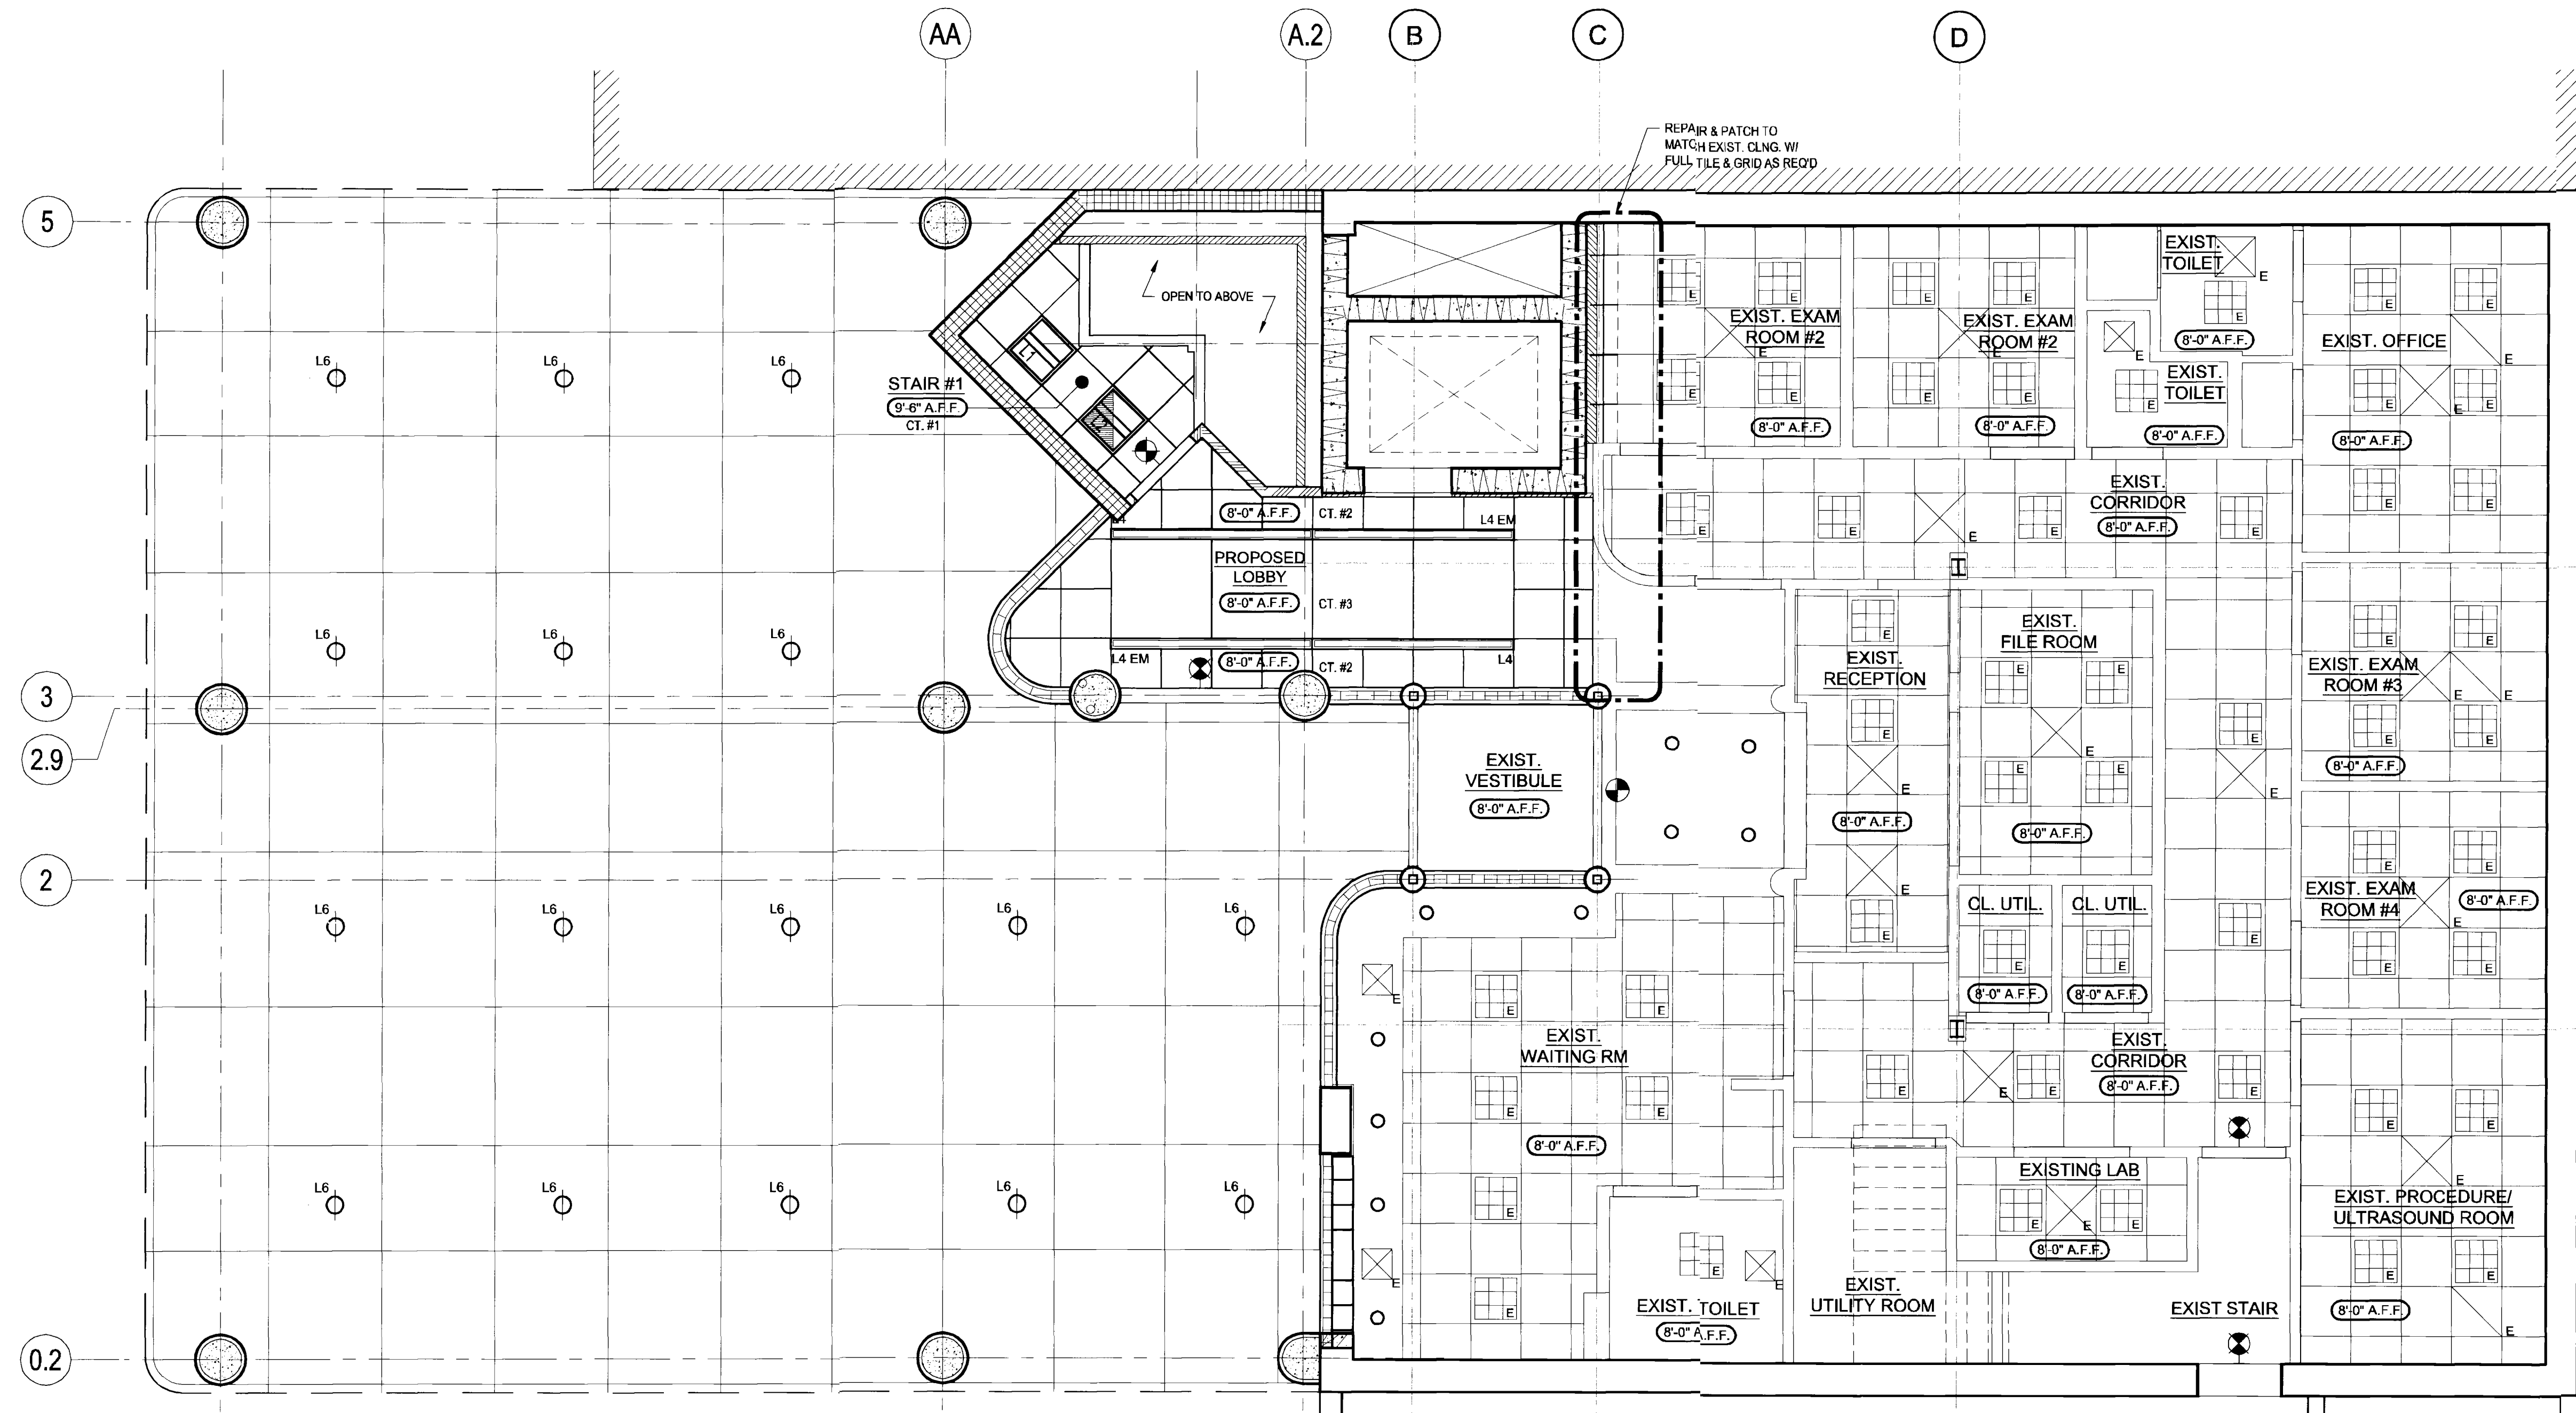

1
A-103
PROPOSED FIRST FLOOR REFLECTED CEILING PLAN
SCALE: 1/4" = 1'-0"
SCALE: 1/4" = 1'-0"

NOTE:
ALL CEILING GRID SHALL BE CENTERED WITHIN THE INDIVIDUAL ROOM OR SPACE UNLESS NOTED OTHERWISE ON DRAWINGS.

CONTRACTOR TO PROVIDE SHOP DRAWINGS FOR REVIEW BY ARCHITECT/ENGINEER FOR:
• CEILING TILE & GRID.
• LIGHT FIXTURES.
• SUPPLY & RETURN DIFFUSERS.

- PLAN NOTES**
- CONTRACTOR SHALL BE RESPONSIBLE TO FIELD VERIFY THE EXISTING CONDITIONS OF THE DEMISED SPACE AND REPORT ANY DISCREPANCIES BETWEEN THE ACTUAL CONDITIONS AND THE DRAWINGS TO THE ARCHITECT PRIOR TO THE COMMENCEMENT OF WORK.
 - CONTRACTOR SHALL BE RESPONSIBLE TO PATCH AND REPAIR ALL EXISTING SURFACES WHERE DISTURBED BY THE WORK TO MATCH AND ALIGN WITH EXISTING ADJACENT SURFACES.


PROPOSED CEILING LEGEND											
	QUANTITY		SYMBOL	SPECIFICATIONS	QUANTITY		SYMBOL	SPECIFICATIONS			
	1ST	2ND			1ST	2ND					
	1	25		2'-0" x 2'-0" x 1/2" LED RECESSED LIGHT TROFFER NATIONAL LIGHTING MODEL # 225-LED-LPA-T-VOLT-ED WATTAGE: 30 W. COLOR: 3500K VOLTAGE: 120V OPTIONS: EM (WHERE NOTED ON REFLECTED CEILING PLAN)	0	12		RECESSED LED DOWNLIGHT NATIONAL LIGHTING MODEL # NATLS08-LED-FD14W-30K-KE-AR6466-24" BAR COLOR: 3500K TRIM: SOLITE # 493 WBS D6 HOUSING: # H750ICAT WATTAGE: 14 W.		GYPSUM BOARD CEILING	
	1	19		3 1/2" W x 8'-0" L x 5 1/4" LED RECESSED LIGHT FIXTURE NATIONAL LIGHTING MODEL # NICHE-2NR-LED-SFA-T-UNV-ED WATTAGE: 50 W. COLOR: 3500K OPTIONS: EM (WHERE NOTED ON REFLECTED CEILING PLAN)	16	0		RECESSED 1/2" LED DOWNLIGHT @ 1ST FLOOR EXTERIOR NATIONAL LIGHTING MODEL # NATLS08-FRM-LED-43W-UNV-ED WATTAGE: 43 W. COLOR: 3500K OPTION: EM (WHERE NOTED ON REFLECTED CEILING PLAN)		CEILING GRILLE - SEE MECHANICAL PLANS	
	0	1		3 1/2" W x 8'-0" L x 5 1/4" LED RECESSED LIGHT FIXTURE 8'-0" L @ 1ST FLOOR NATIONAL LIGHTING MODEL # NICHE-2NR-LED-SFA-T-UNV-ED WATTAGE: 30 W. COLOR: 3500K OPTIONS: EM (WHERE NOTED ON CEILING PLAN)	2	9		NEW EMERGENCY EXIT LIGHT - WALL MOUNTED COOPER LIGHTING - SURE LITE LED MODEL # LPX-7-WGS11 VOLTAGE = 120V WATTS PER FIXTURE = 98 WATTS		CEILING DIFFUSER - SEE MECHANICAL PLANS	
	2	3									
	2	1									
NOTE: SEE FINISH SCHEDULE DWG A-802											

EXISTING / DEMO CEILING LEGEND											
	2'-0" x 2'-0"		2'-0" x 2'-0"		EXISTING WALL-MOUNTED EMERGENCY EXIT LIGHT		EXISTING SUSPENDED CEILING TO BE REMOVED				
	2'-0" x 2'-0"		2'-0" x 2'-0"		EXISTING SPRINKLER HEAD		EXISTING CEILING DIFFUSER TO BE REMOVED				
	2'-0" x 2'-0"		EXISTING RECESSED SPOT LIGHT		EXISTING LIGHTING FIXTURE TO BE REMOVED		EXISTING CEILING RETURN TO BE REMOVED				

NO.	DATE	ISSUED TO	COMMENT
12.22.14	ISSUED TO	DOB	

OWNER/CLIENT

DR. HERB MOSBERG
189-04 HILLSIDE AVENUE
HOLLIS, NEW YORK

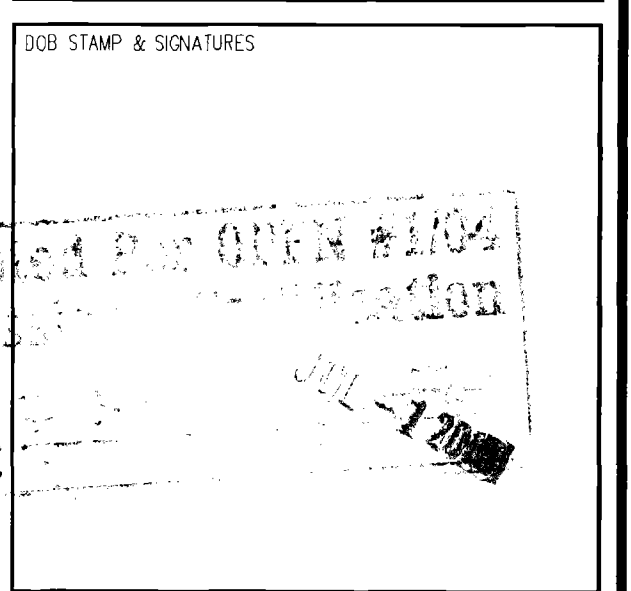

STRUCTURAL ENGINEER

PBA ENGINEERING, P.C.
Structural Engineers
12 Kudo Road, Fairfield, New Jersey 07004-1383
E-Mail: pba@pbaeng.com Phone: (973) 776-1700
Fax: (973) 776-2100
© Copyright 2012 PBA Engineering, P.C. - All Rights Reserved

MEP ENGINEER

H&M
H&M ENGINEERING SERVICES, P.C.
ENGINEERING CONSULTANTS
110 Riverside Turnpike, Suite 203
Floral Park, New York 11001
E-Mail: h&m@h&meng.com
Tel: (516) 466-6221

rosenbaum design group
architecture
Rand K. Rosenbaum ARCHITECT
2021 WARDEN AVENUE Tel: 516.616.6171
LOBBY EAST WING Fax: 516.616.6221
LAKE SUCCESS, NEW YORK 11042-1011 mol@r-d-g.com

PROJECT

SOUTHEAST MEDICAL BUILDING
189-04 HILLSIDE AVENUE
HOLLIS, NEW YORK

SHEET TITLE

PROPOSED FIRST FLOOR REFLECTED CEILING PLAN

REGISTERED ARCHITECT
NEW YORK STATE
No. 22553
2/24/2015

DRAWN BY: JAG
CHECKED BY: RCF
DATE: 07.18.14

SWG NUMBER
A-103.00

14046 16 OF 32